


N

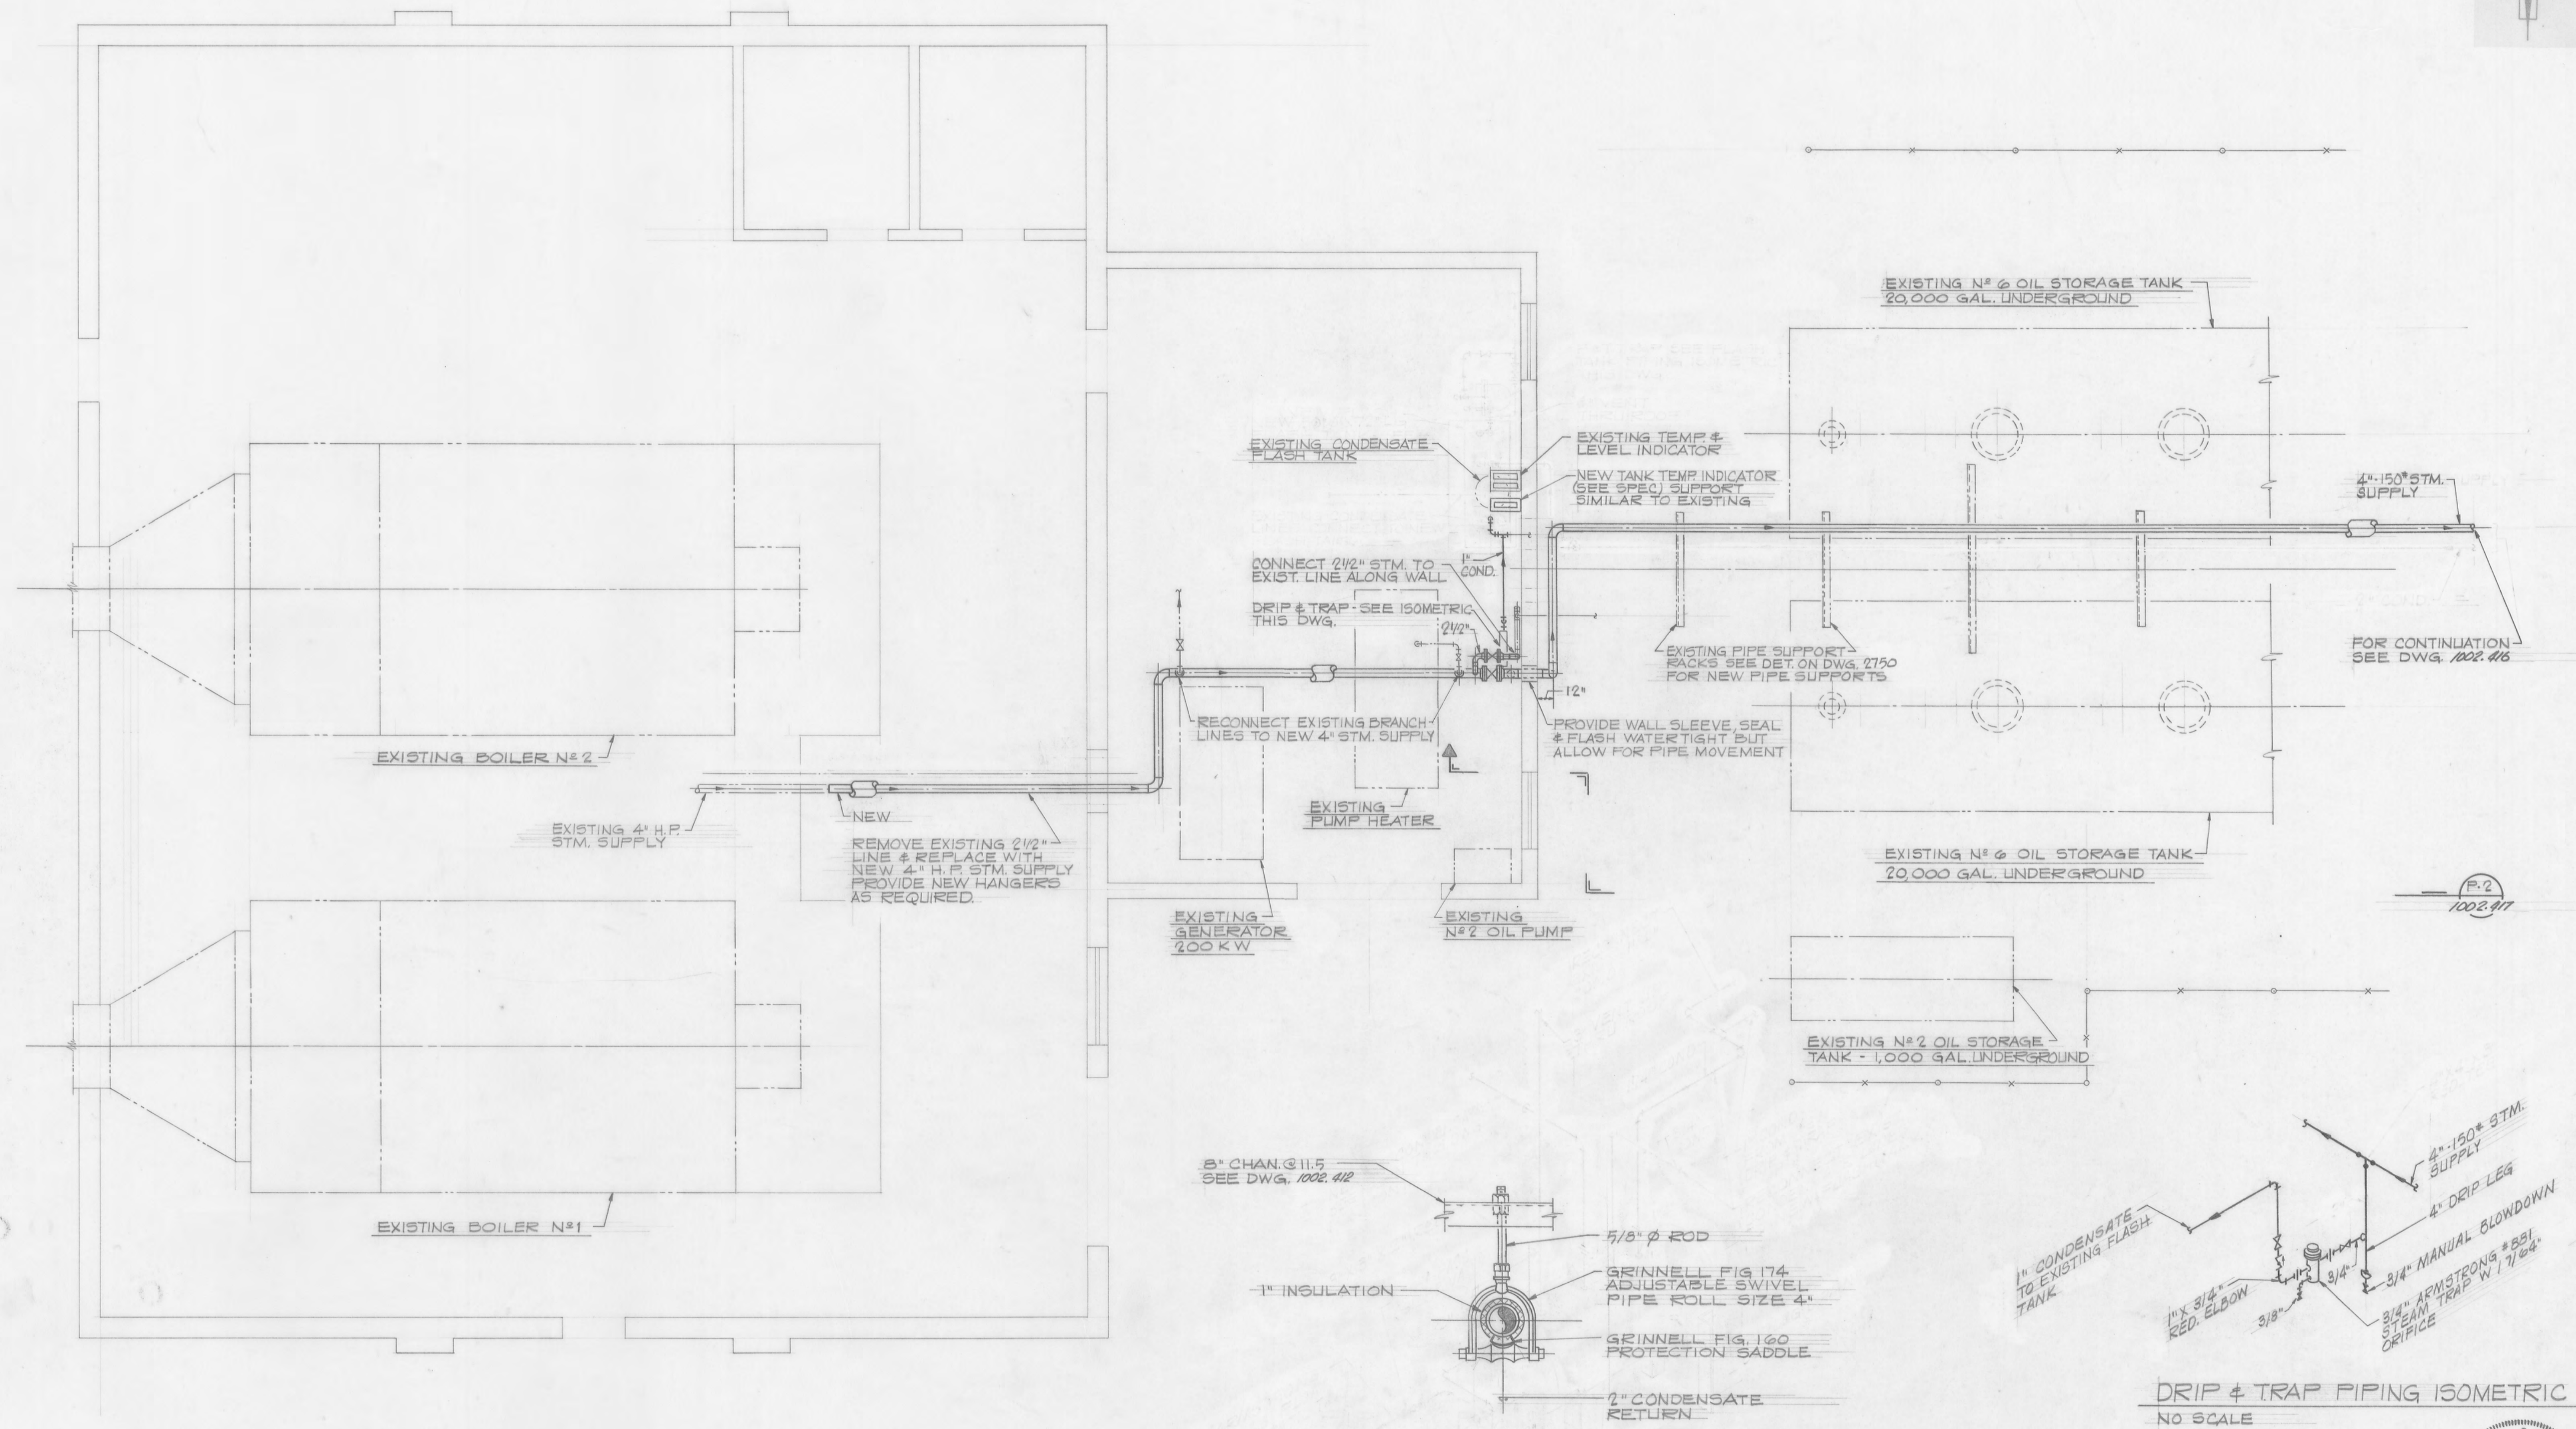

PIPE SUPPORT DETAIL
SCALE: 1/2" = 1'-0"

PREVIOUS STAFFORD ET AL. DWG. NO. 2748.

STAFFORD · GIFFELS · BERGSTROM · FRICKER
ENGINEERS · ARCHITECTS · PLANNERS

DATE APRIL 1975	DAVENNA ARSENAL INC. DAVENNA OHIO	JOB NO. 75-11
SCALE 1/4" = 1'-0"	FUEL STORAGE TANK INSTALLATION	DRAWING NO. 1002.415
DRAWN BY N & B	PIPING PLAN	REV.



VERIFY ALL DIMENSIONS AT THE SITE