





SECOND FLOOR PLAN
SCALE 1/4" = 1'-0" FLEL 1165.00

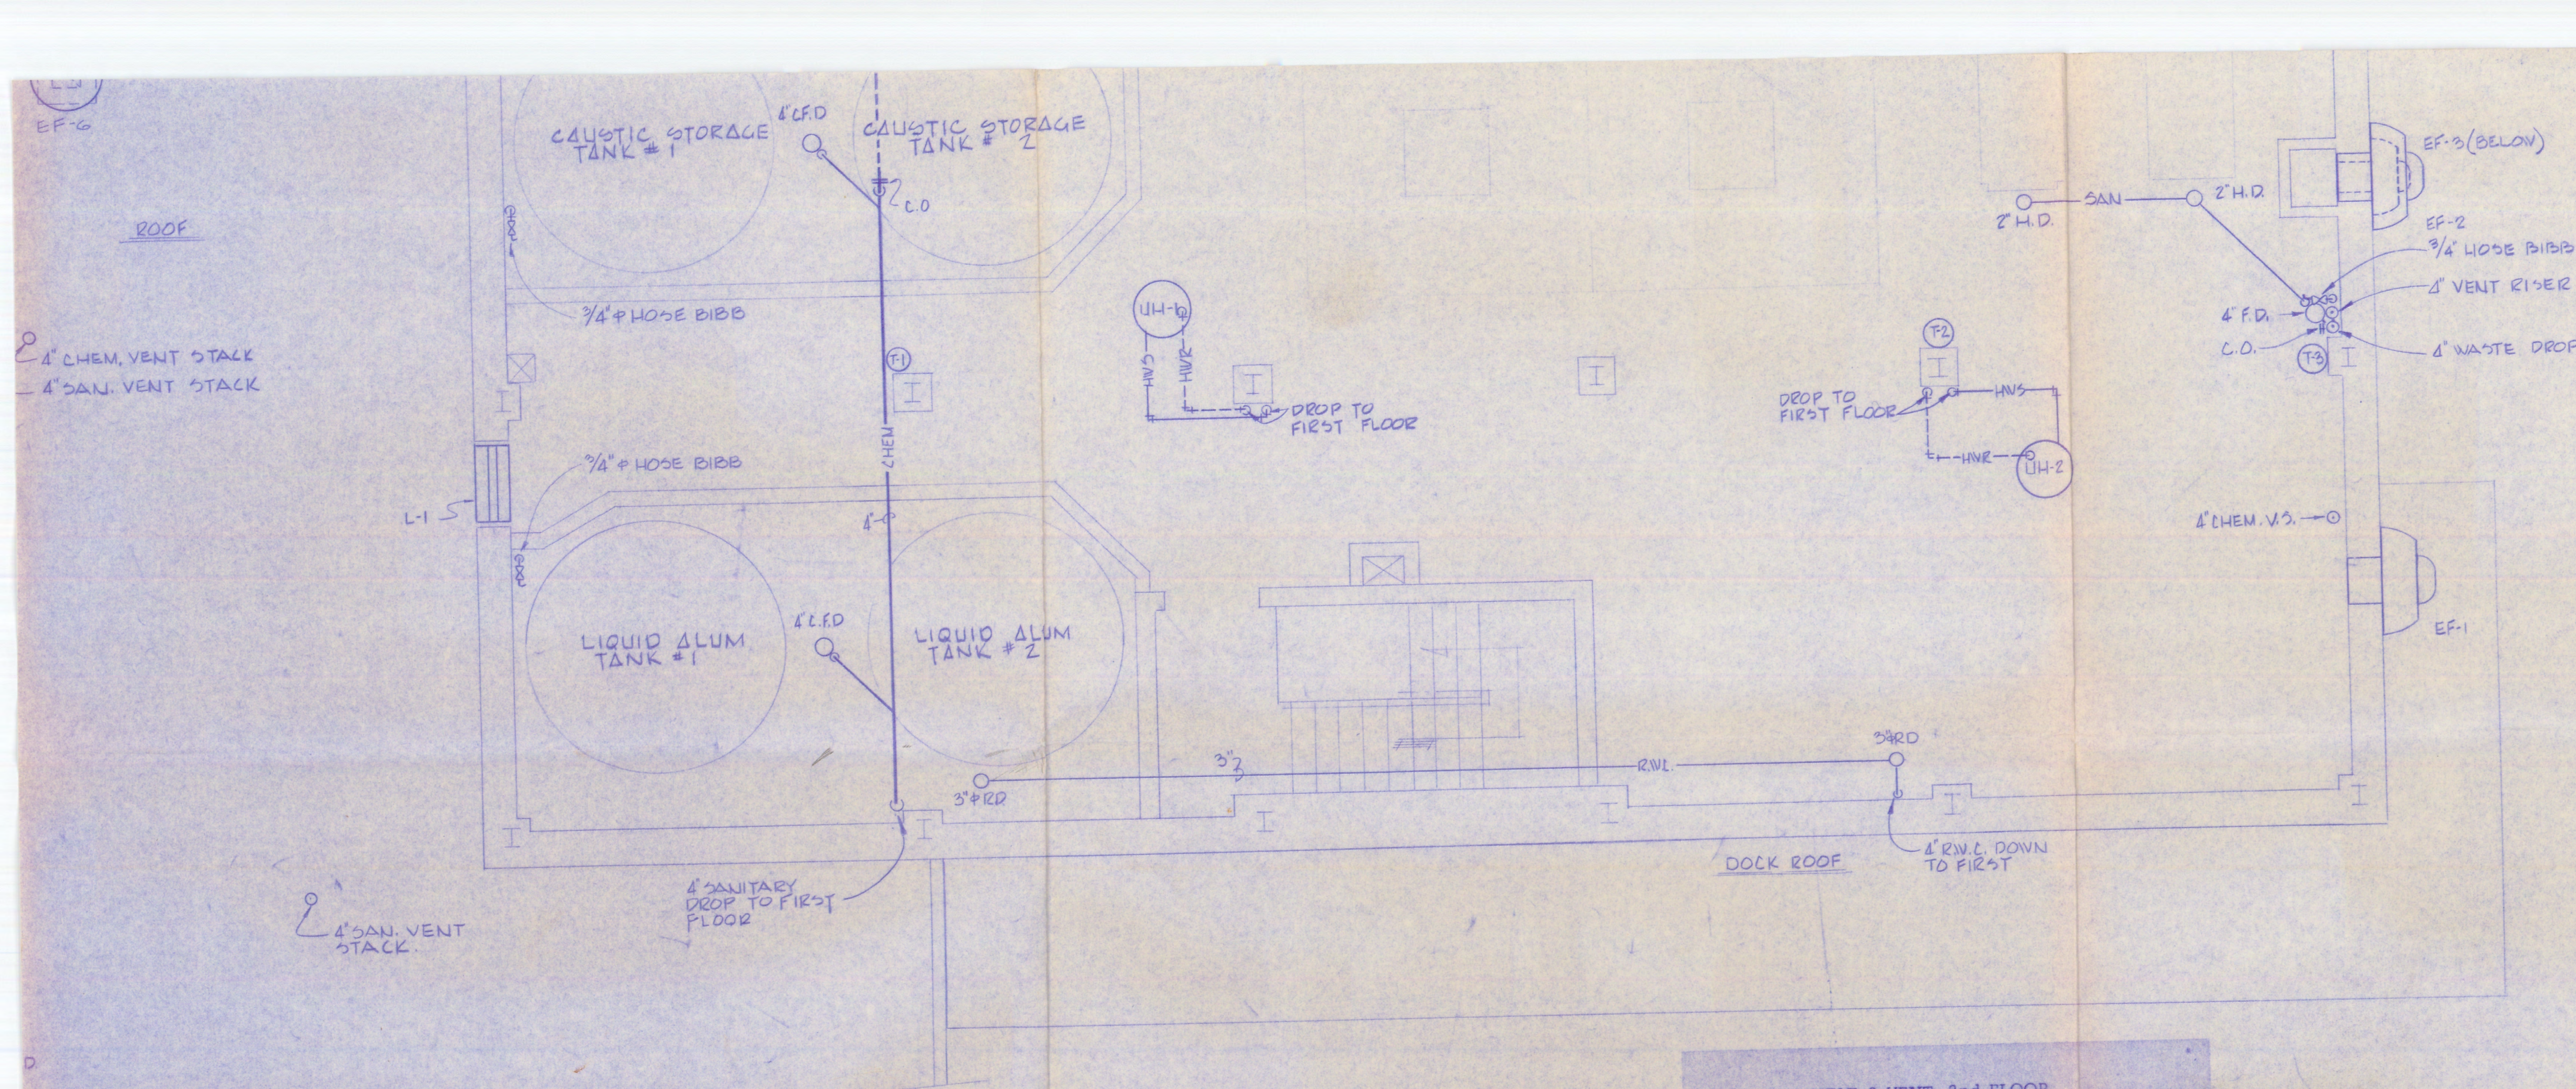


HEAT & VENT 2nd FLOOR
SEQUENCE OF OPERATION


1. Heating:
Unit heaters UH-1 and UH-2 cycle as required to maintain space temperature from single stage heating thermostats T-1 and T-2 respectively.
2. Cooling:
1st stage of 2nd stage cooling thermostat T-3 opens dampers of louvers, 2nd stage starts exhaust fan EF-1.

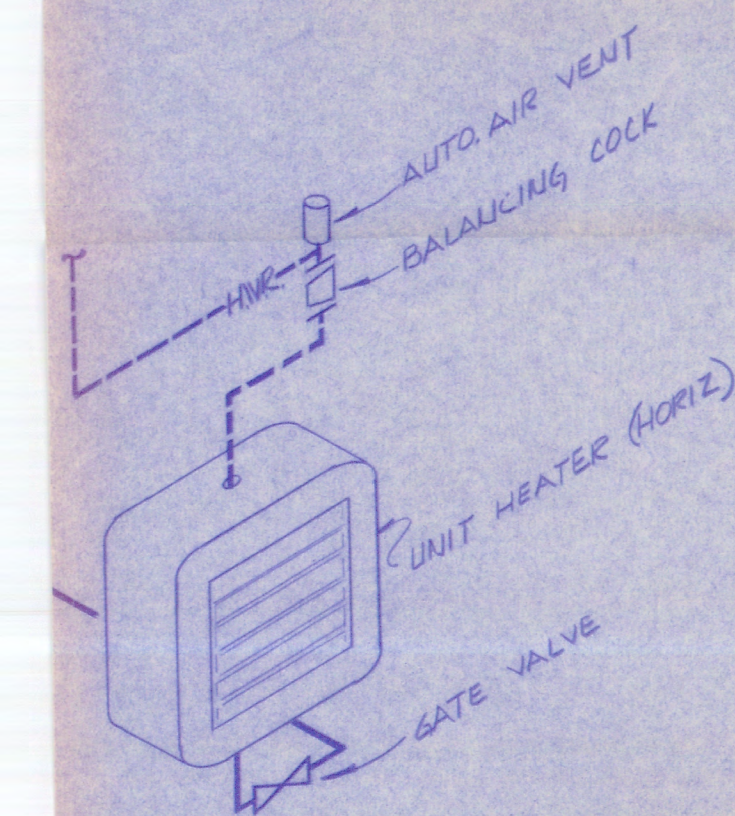


TAL UNIT HEATER (TYP)

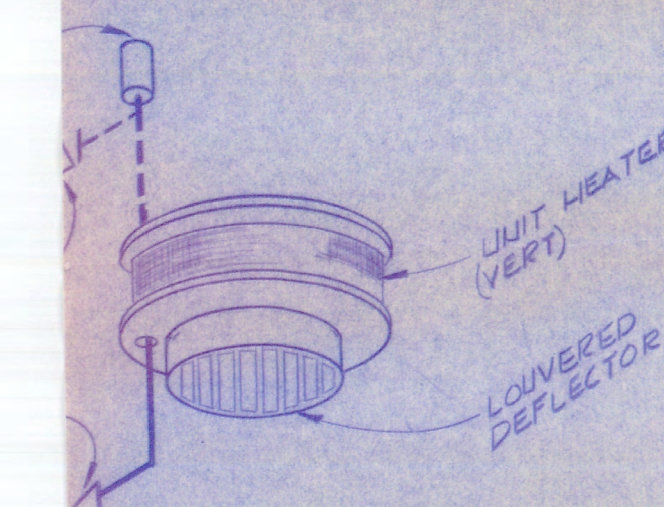


L UNIT HEATER (TYP)

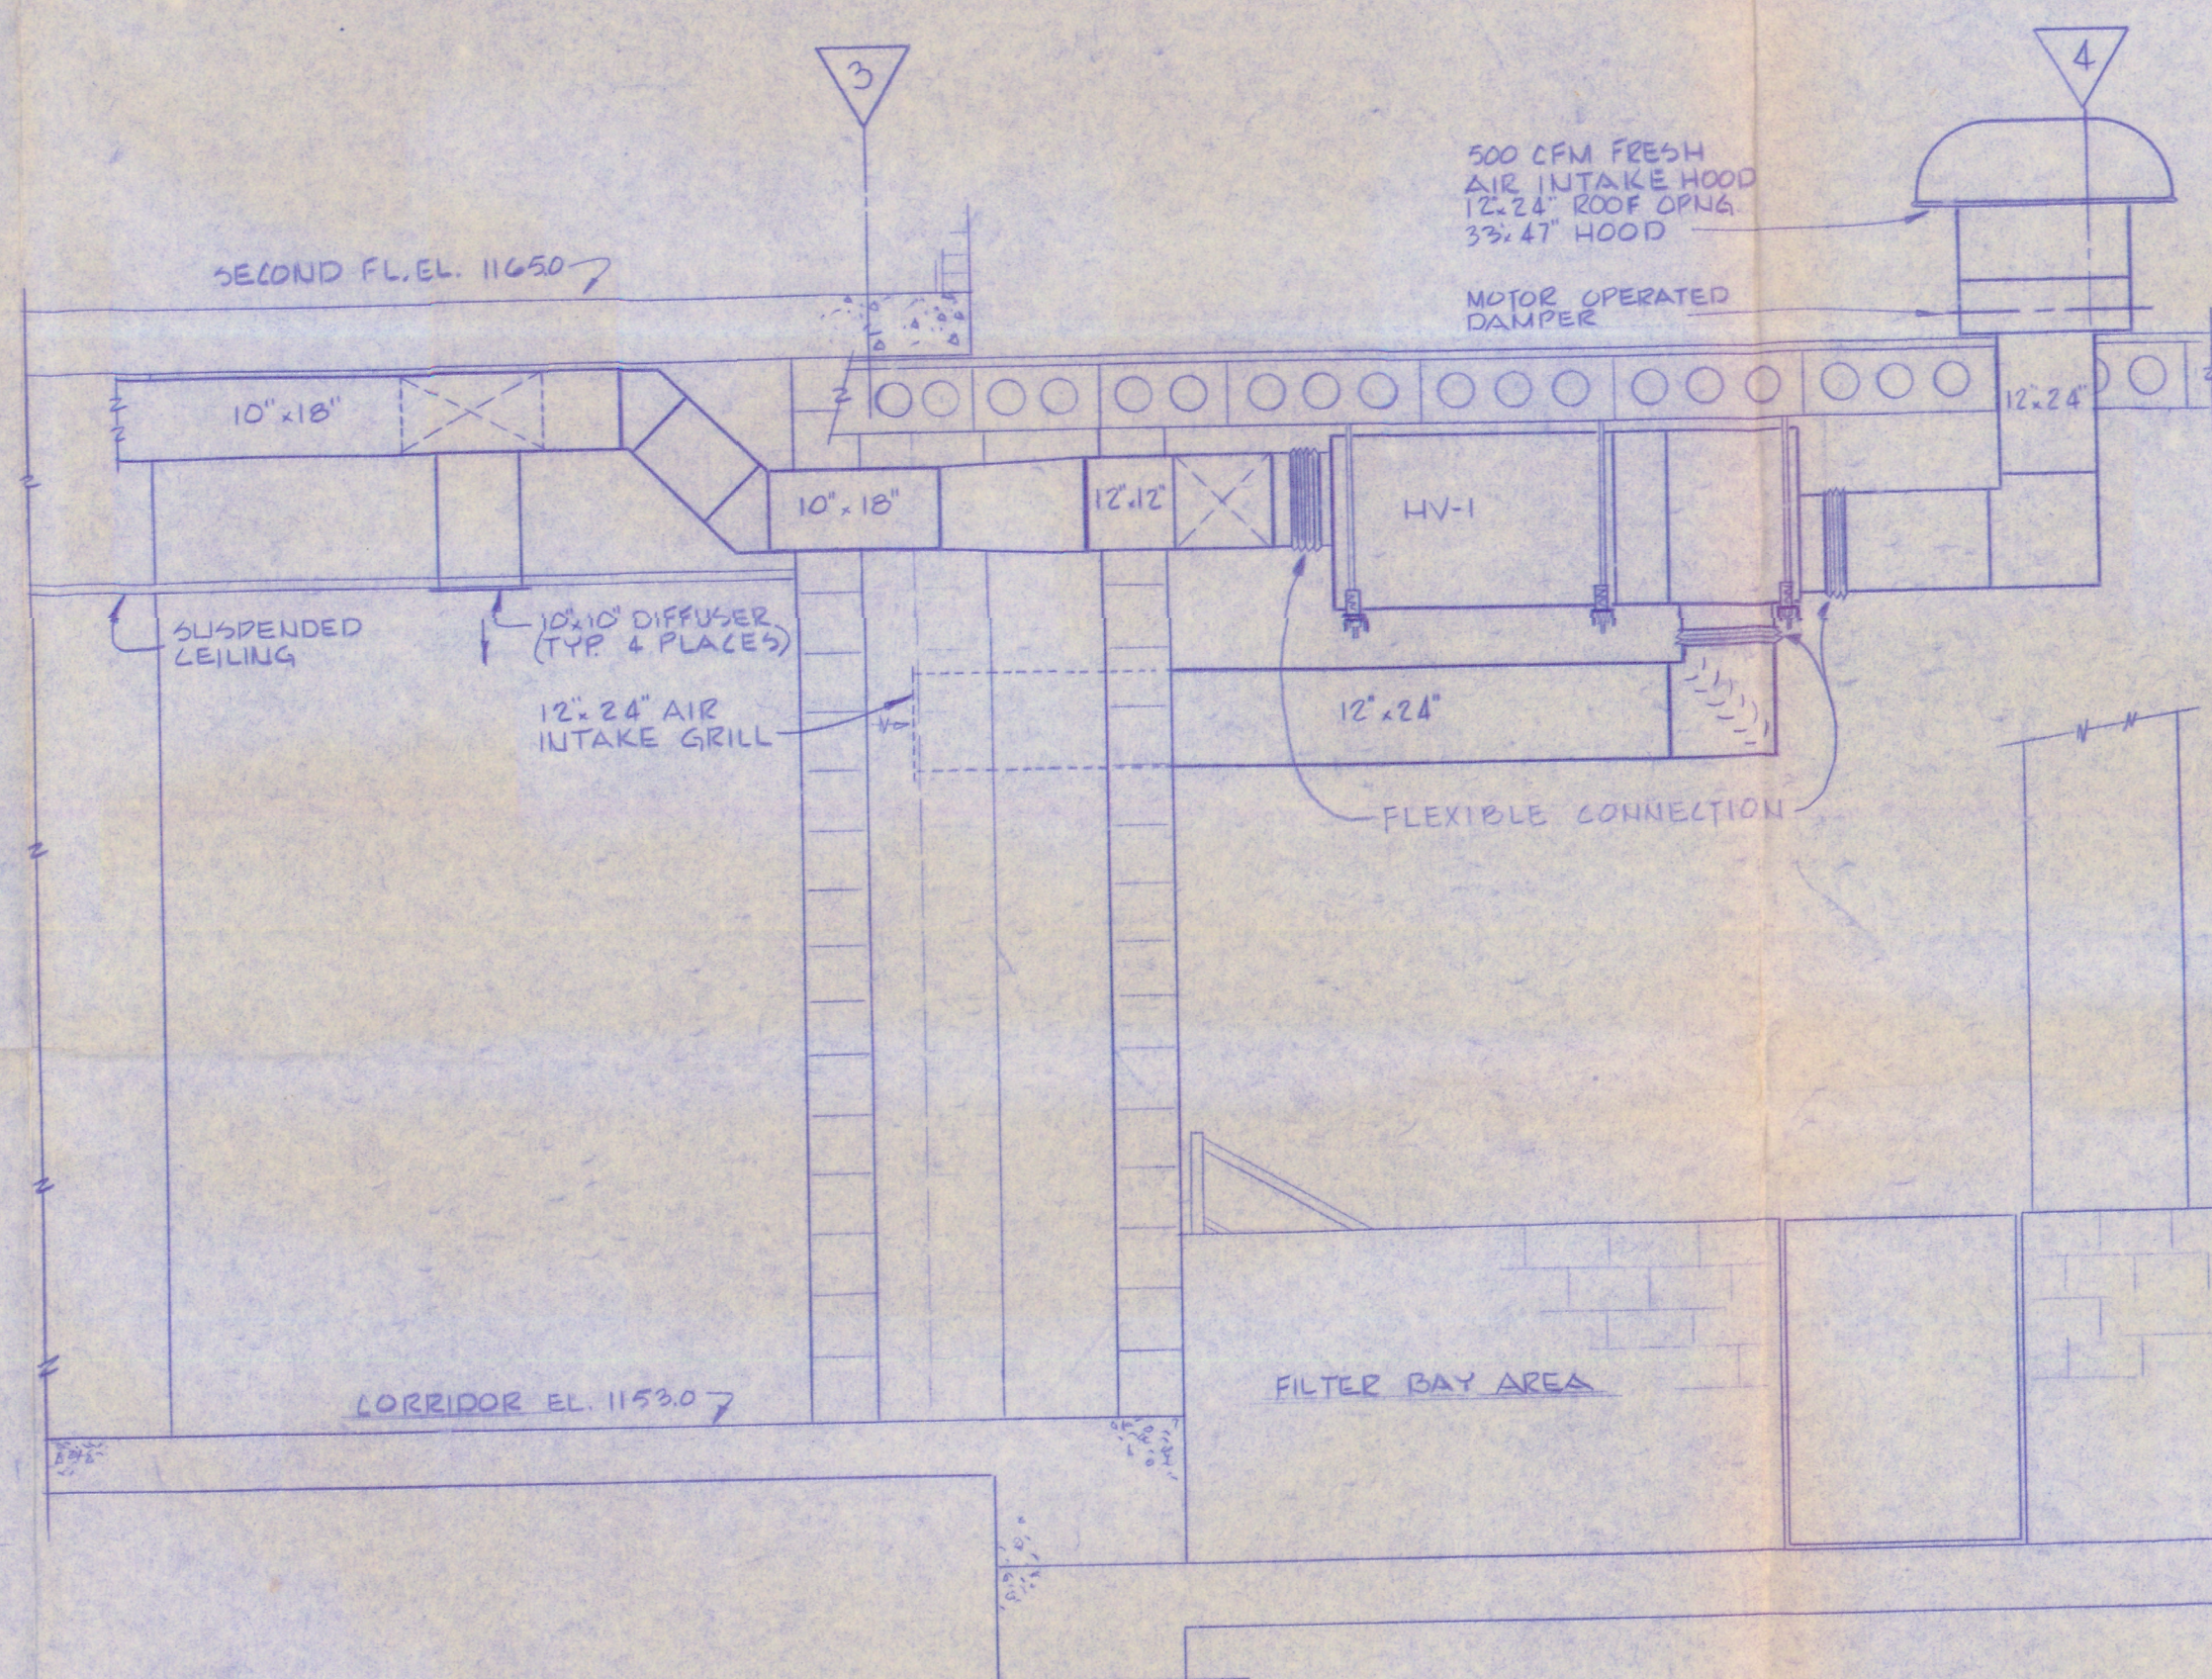

SECTION 5
SCALE 1/2" = 1'-0"

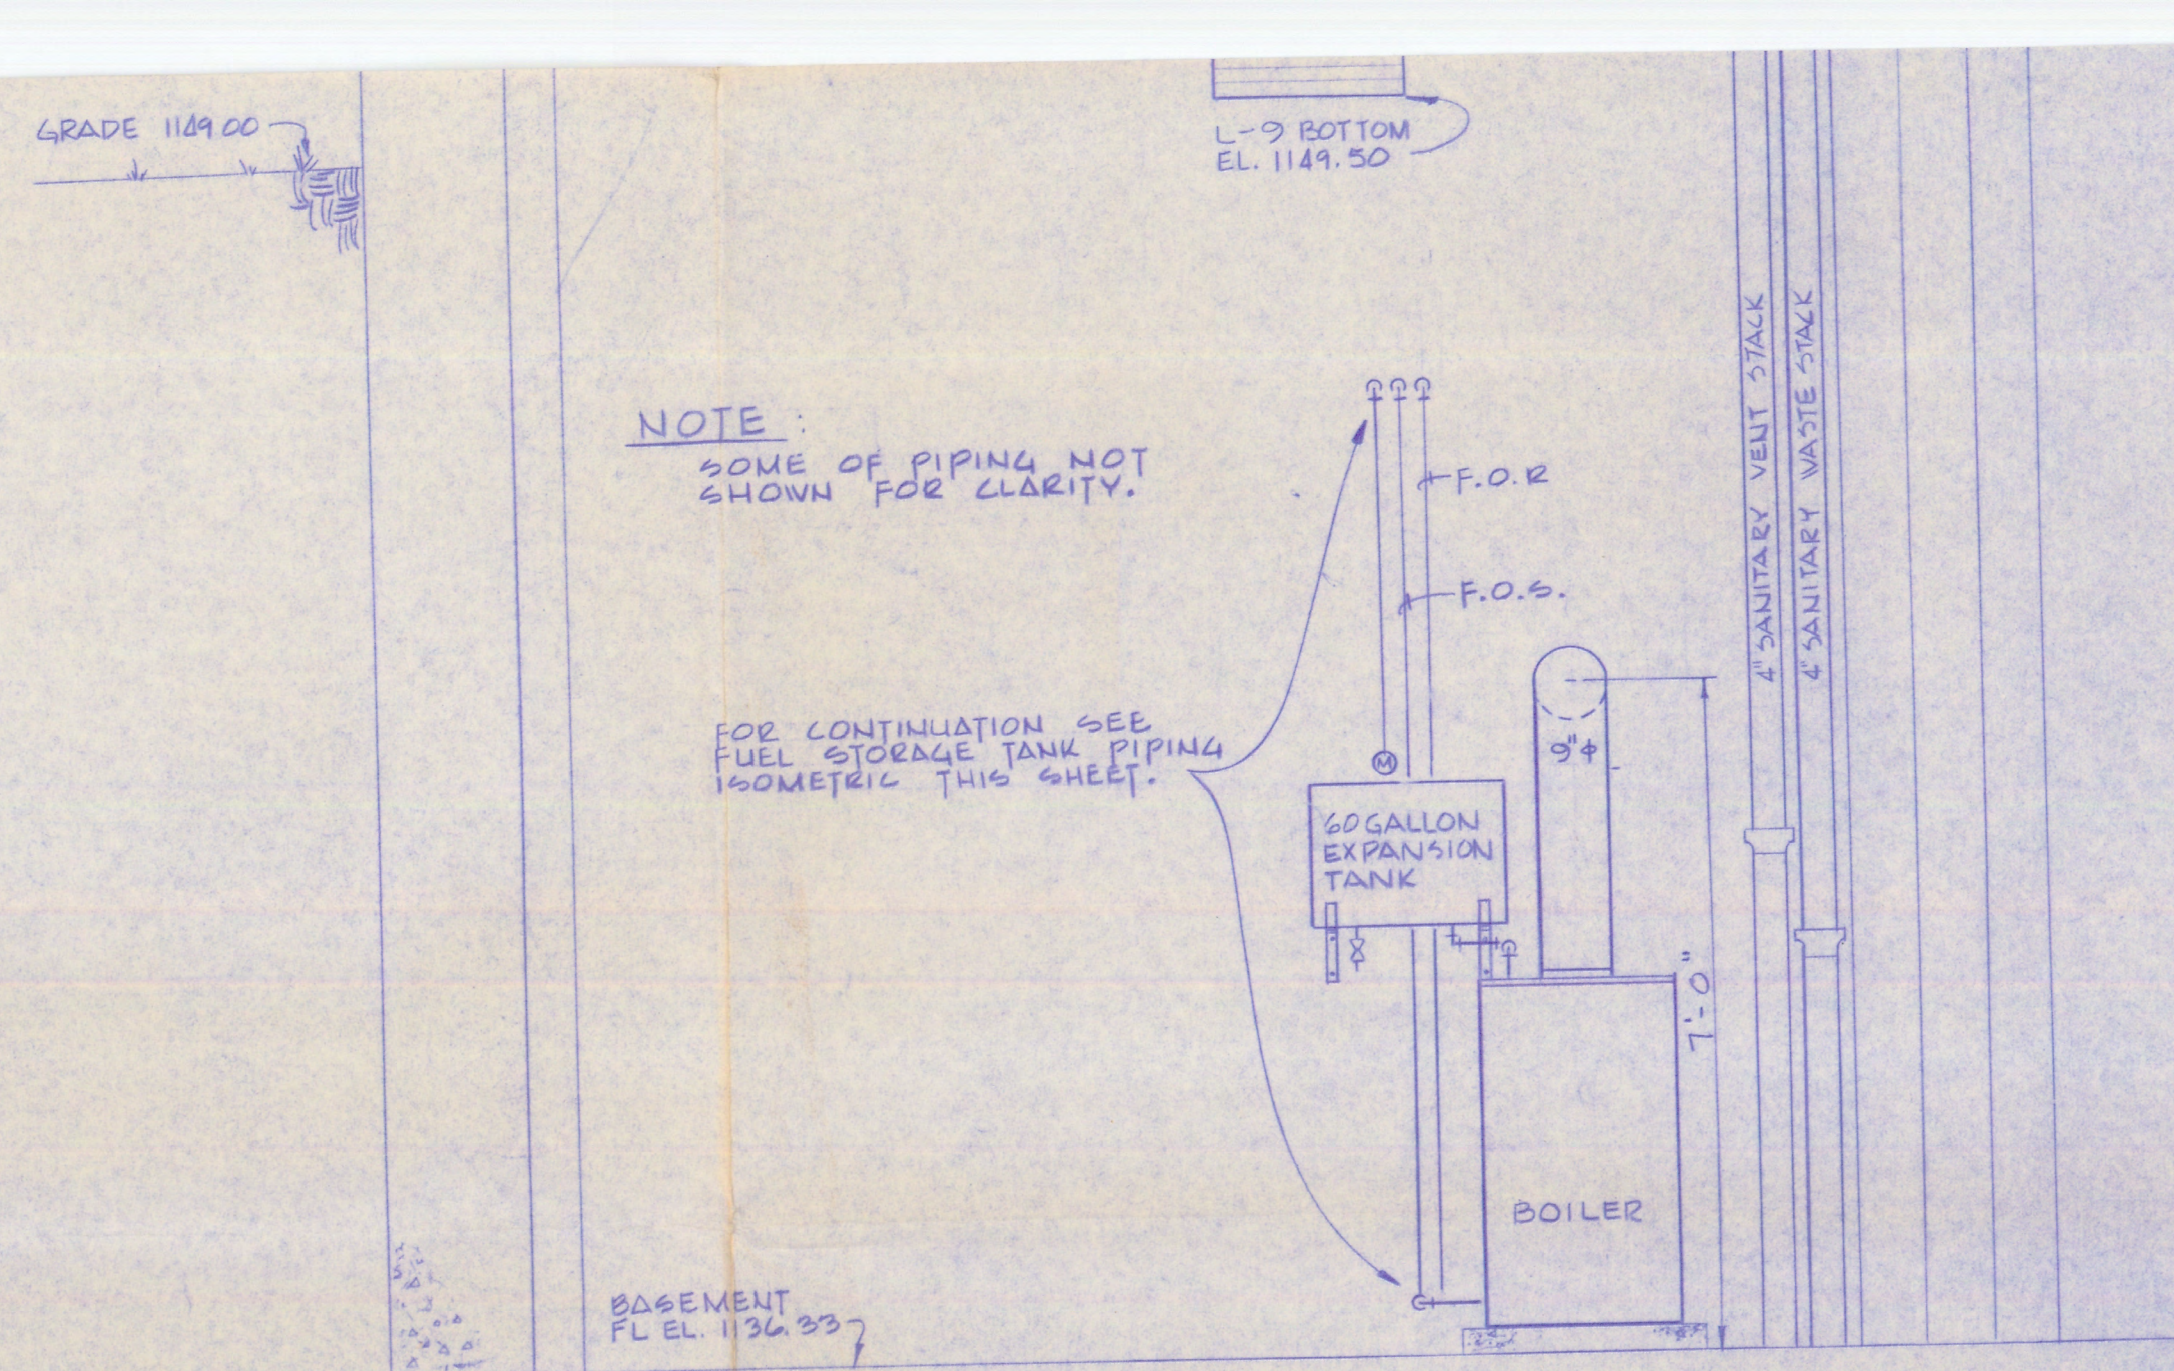


SECTION 4
SCALE 1/2" = 1'-0"

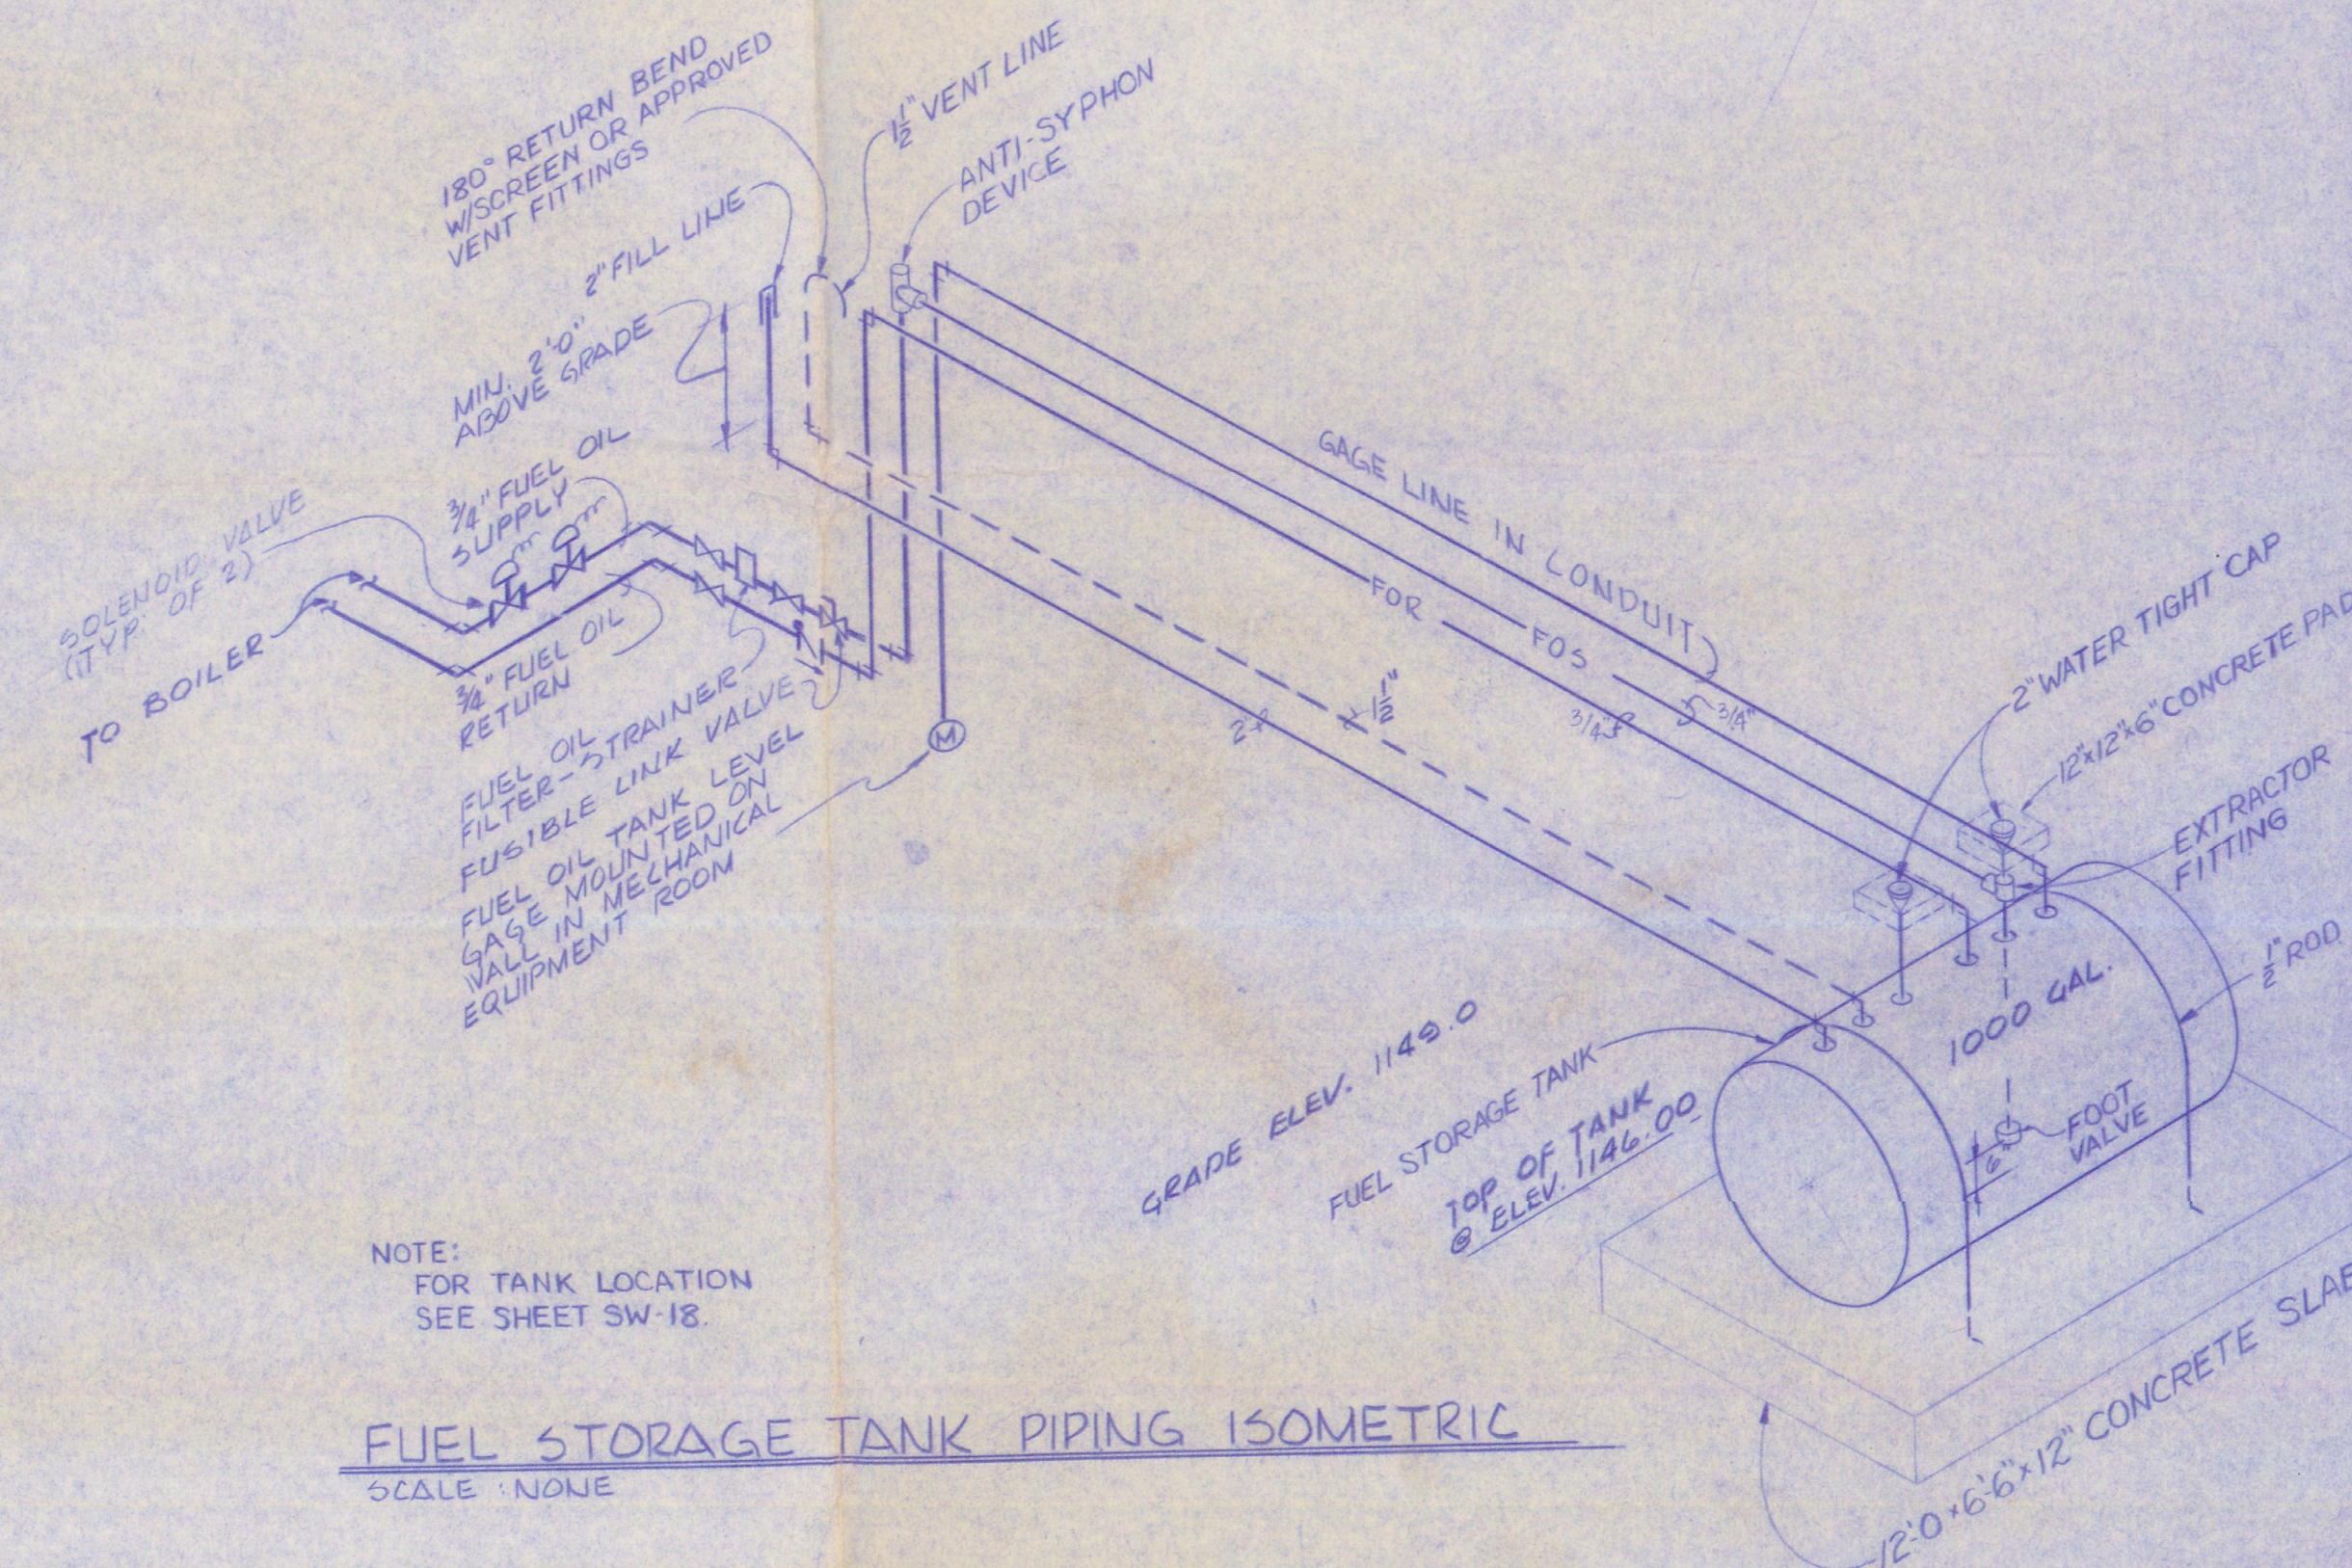

NOTE:
FOR TANK LOCATION
SEE SHEET SW-18.

FUEL STORAGE TANK PIPING ISOMETRIC
SCALE: NONE

GRAPHIC SCALES

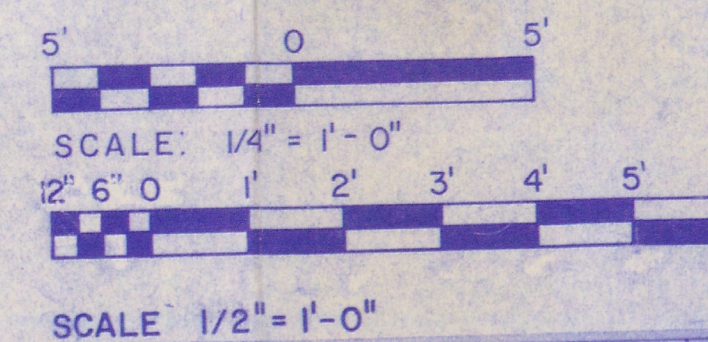

ALDEN E. STILSON & ASSOCIATES
CONSULTING ENGINEERS
170 NORTH HIGH STREET
COLUMBUS, OHIO

DRAWN: S.J.M.
CHECKED: J.O.C.
APPROVED: R.G.R.
APPROVED: F.J.M.

REV	DATE	DESCRIPTION	EGH BY
	MAY 80	AS CONSTRUCTED	EGH
DEPARTMENT OF THE ARMY BALTIMORE DISTRICT, CORPS OF ENGINEERS BALTIMORE, MARYLAND			
RAVENNA ARMY AMMUNITION PLANT, OHIO NEW WATER SUPPLY & TREATMENT FACILITIES SURFACE WATER TREATMENT PLANT MECHANICAL SECOND FLOOR PLAN & DETAILS			
DRAWING NUMBER		PLATE	
26-04-06		70	
AS-BLT.			
SCALE: NOTED	DATE: 12-23-75	SHEET M-70	