


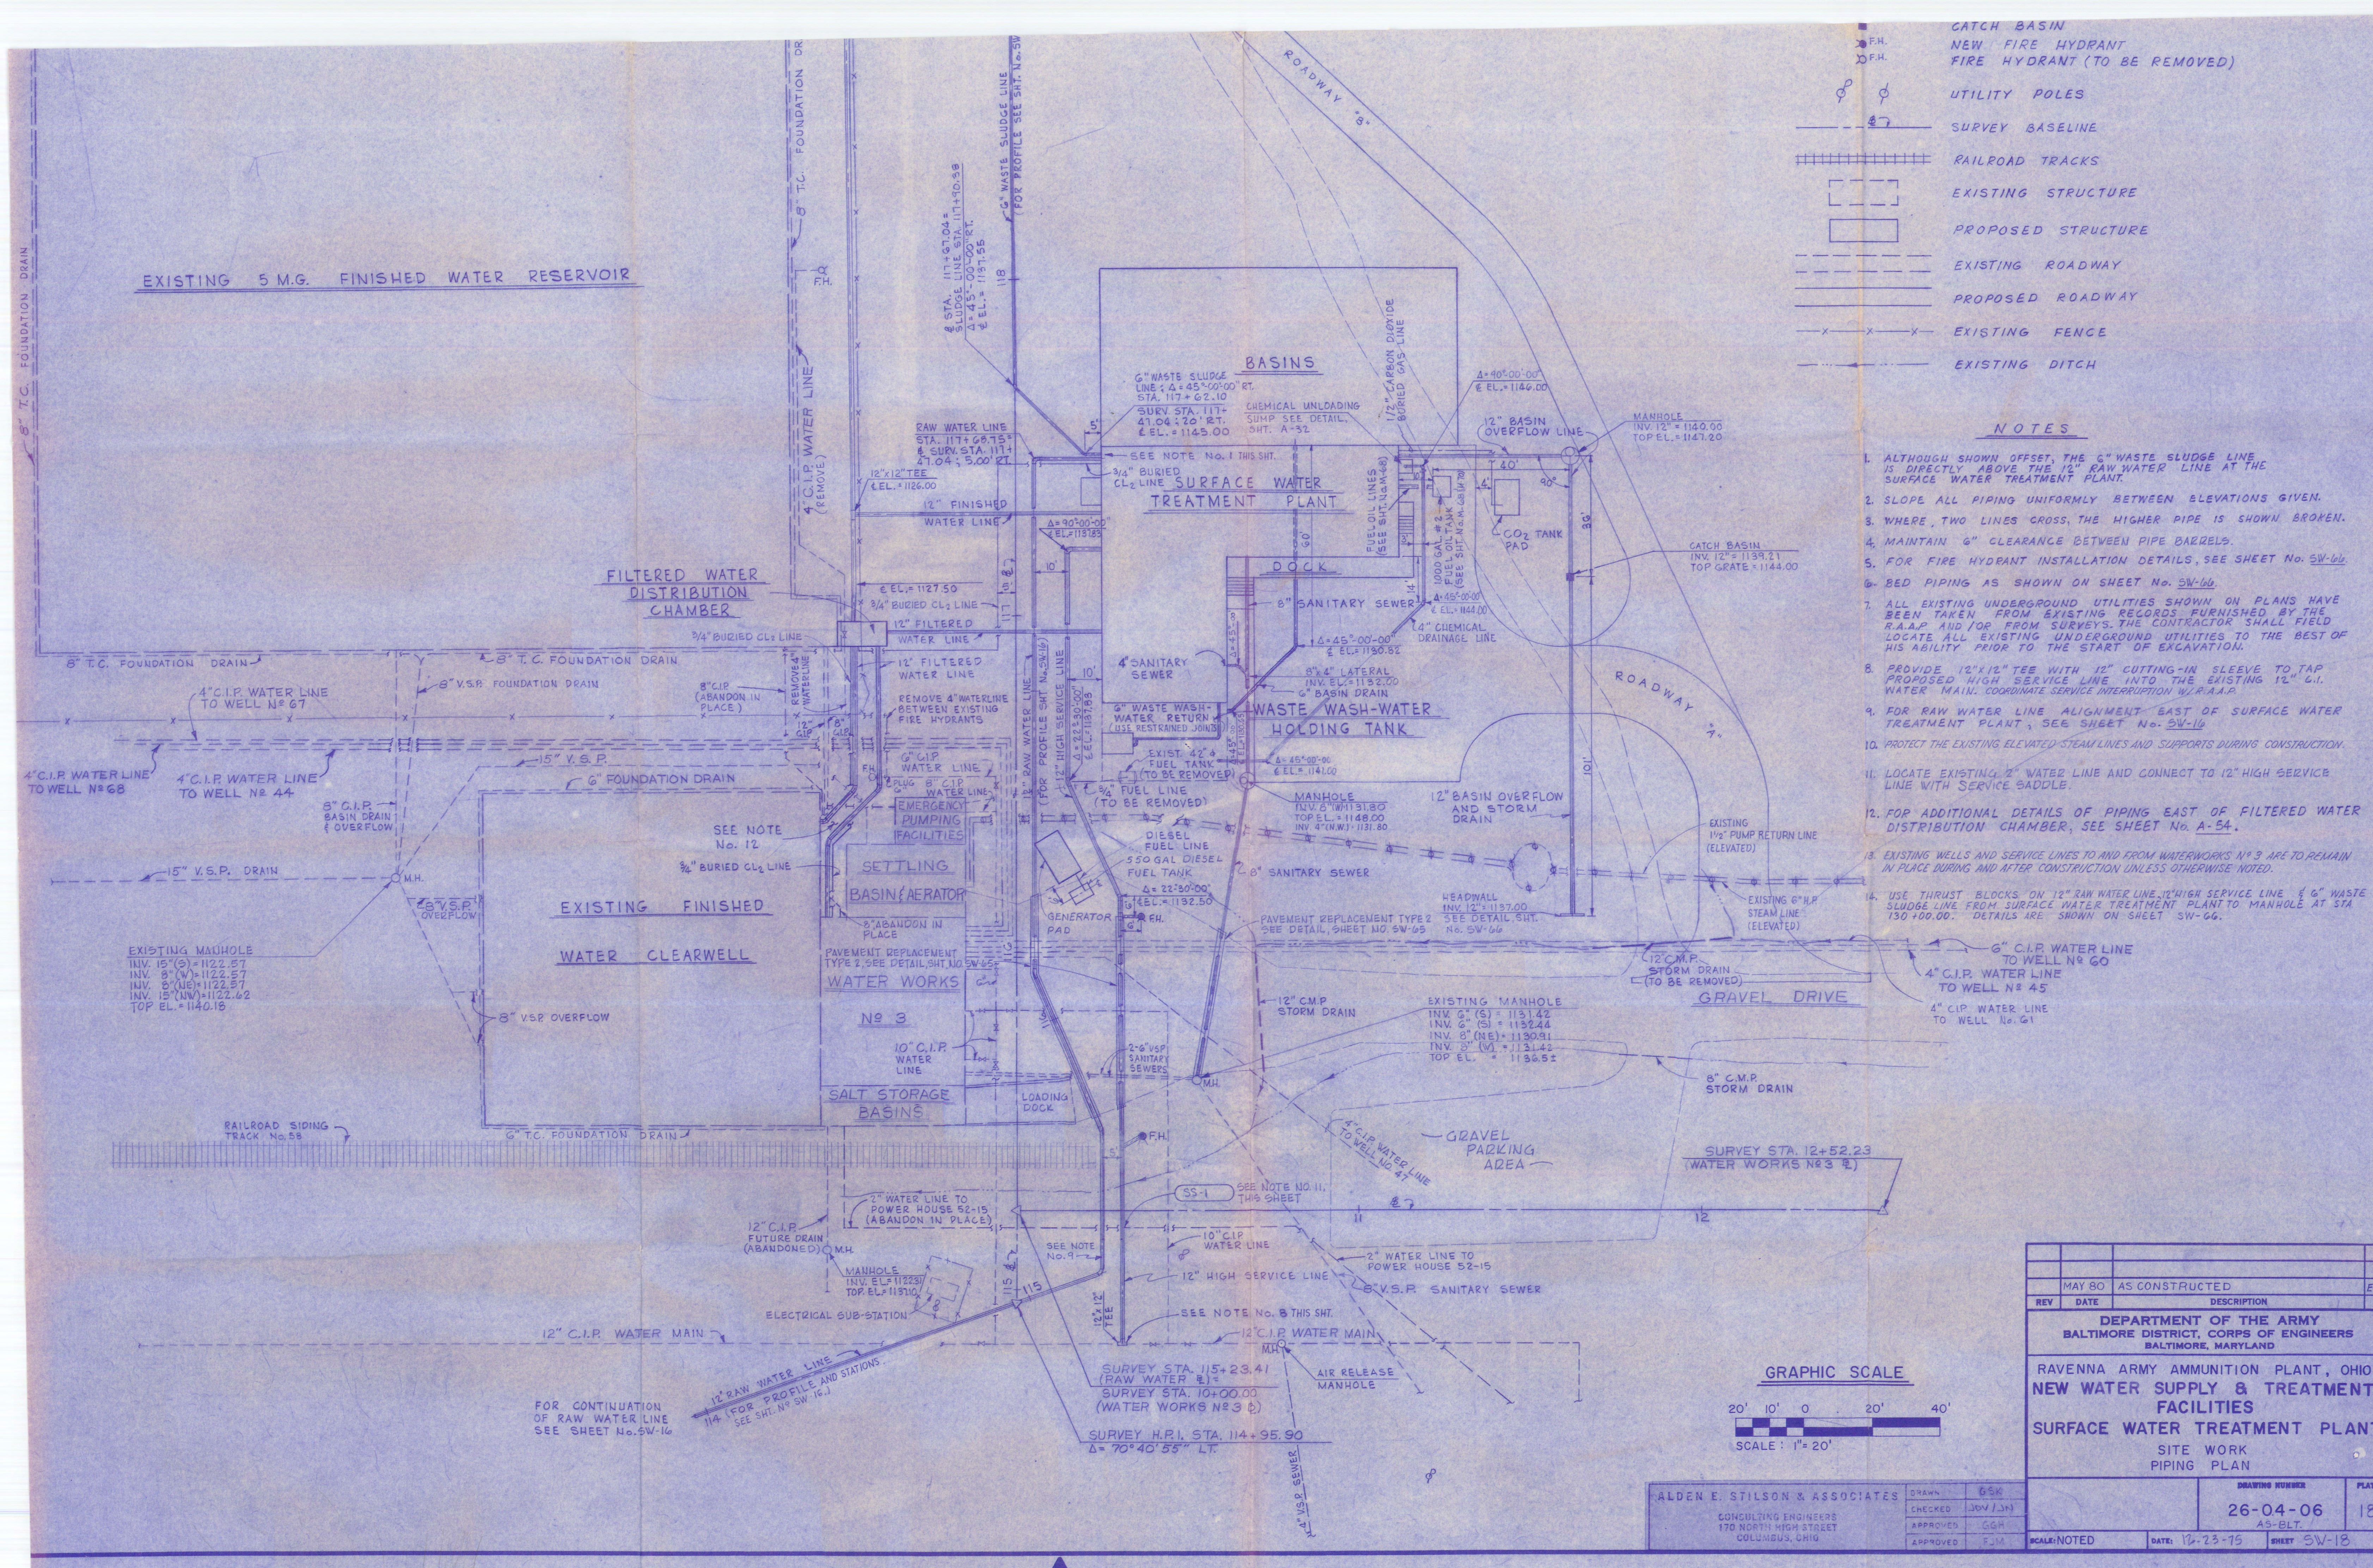


CATCH BASIN
NEW FIRE HYDRANT
FIRE HYDRANT (TO BE REMOVED)

UTILITY POLES
SURVEY BASELINE
RAILROAD TRACKS
EXISTING STRUCTURE
PROPOSED STRUCTURE
EXISTING ROADWAY
PROPOSED ROADWAY
EXISTING FENCE
EXISTING DITCH

NOTES

- ALTHOUGH SHOWN OFFSET, THE 6" WASTE SLUDGE LINE IS DIRECTLY ABOVE THE 12" RAW WATER LINE AT THE SURFACE WATER TREATMENT PLANT.
- SLOPE ALL PIPING UNIFORMLY BETWEEN ELEVATIONS GIVEN.
- WHERE TWO LINES CROSS, THE HIGHER PIPE IS SHOWN BROKEN.
- MAINTAIN 6" CLEARANCE BETWEEN PIPE BARRELS.
- FOR FIRE HYDRANT INSTALLATION DETAILS, SEE SHEET No. SW-66.
- BED PIPING AS SHOWN ON SHEET No. SW-66.
- ALL EXISTING UNDERGROUND UTILITIES SHOWN ON PLANS HAVE BEEN TAKEN FROM EXISTING RECORDS FURNISHED BY THE R.A.A.P. AND/OR FROM SURVEYS. THE CONTRACTOR SHALL FIELD LOCATE ALL EXISTING UNDERGROUND UTILITIES TO THE BEST OF HIS ABILITY PRIOR TO THE START OF EXCAVATION.
- PROVIDE 12"x12" TEE WITH 12" CUTTING-IN SLEEVE TO TAP PROPOSED HIGH SERVICE LINE INTO THE EXISTING 12" C.I. WATER MAIN. COORDINATE SERVICE INTERRUPTION W/ R.A.A.P.
- FOR RAW WATER LINE ALIGNMENT EAST OF SURFACE WATER TREATMENT PLANT, SEE SHEET No. SW-16.
- PROTECT THE EXISTING ELEVATED STEAM LINES AND SUPPORTS DURING CONSTRUCTION.
- LOCATE EXISTING 2" WATER LINE AND CONNECT TO 12" HIGH SERVICE LINE WITH SERVICE SADDLE.
- FOR ADDITIONAL DETAILS OF PIPING EAST OF FILTERED WATER DISTRIBUTION CHAMBER, SEE SHEET No. A-54.
- EXISTING WELLS AND SERVICE LINES TO AND FROM WATERWORKS NO. 3 ARE TO REMAIN IN PLACE DURING AND AFTER CONSTRUCTION UNLESS OTHERWISE NOTED.
- USE THRUST BLOCKS ON 12" RAW WATER LINE, 12" HIGH SERVICE LINE & 6" WASTE SLUDGE LINE FROM SURFACE WATER TREATMENT PLANT TO MANHOLE AT STA. 150+00.00. DETAILS ARE SHOWN ON SHEET SW-66.

GRAPHIC SCALE

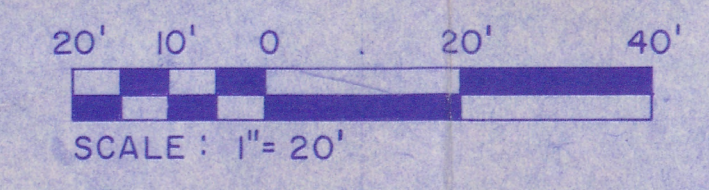

MAY 80		AS CONSTRUCTED	EGH
REV	DATE	DESCRIPTION	BY
DEPARTMENT OF THE ARMY BALTIMORE DISTRICT, CORPS OF ENGINEERS BALTIMORE, MARYLAND			
RAVENNA ARMY AMMUNITION PLANT, OHIO NEW WATER SUPPLY & TREATMENT FACILITIES SURFACE WATER TREATMENT PLANT SITE WORK PIPING PLAN			
DRAWING NUMBER		PLATE	
26-04-06		18	
DATE: 12-23-75		SHEET SW-18	

ALDEN E. STILSON & ASSOCIATES
CONSULTING ENGINEERS
170 NORTH HIGH STREET
COLUMBUS, OHIO

DRAWN GSK
CHECKED JGV/JN
APPROVED GGH
APPROVED FJM